
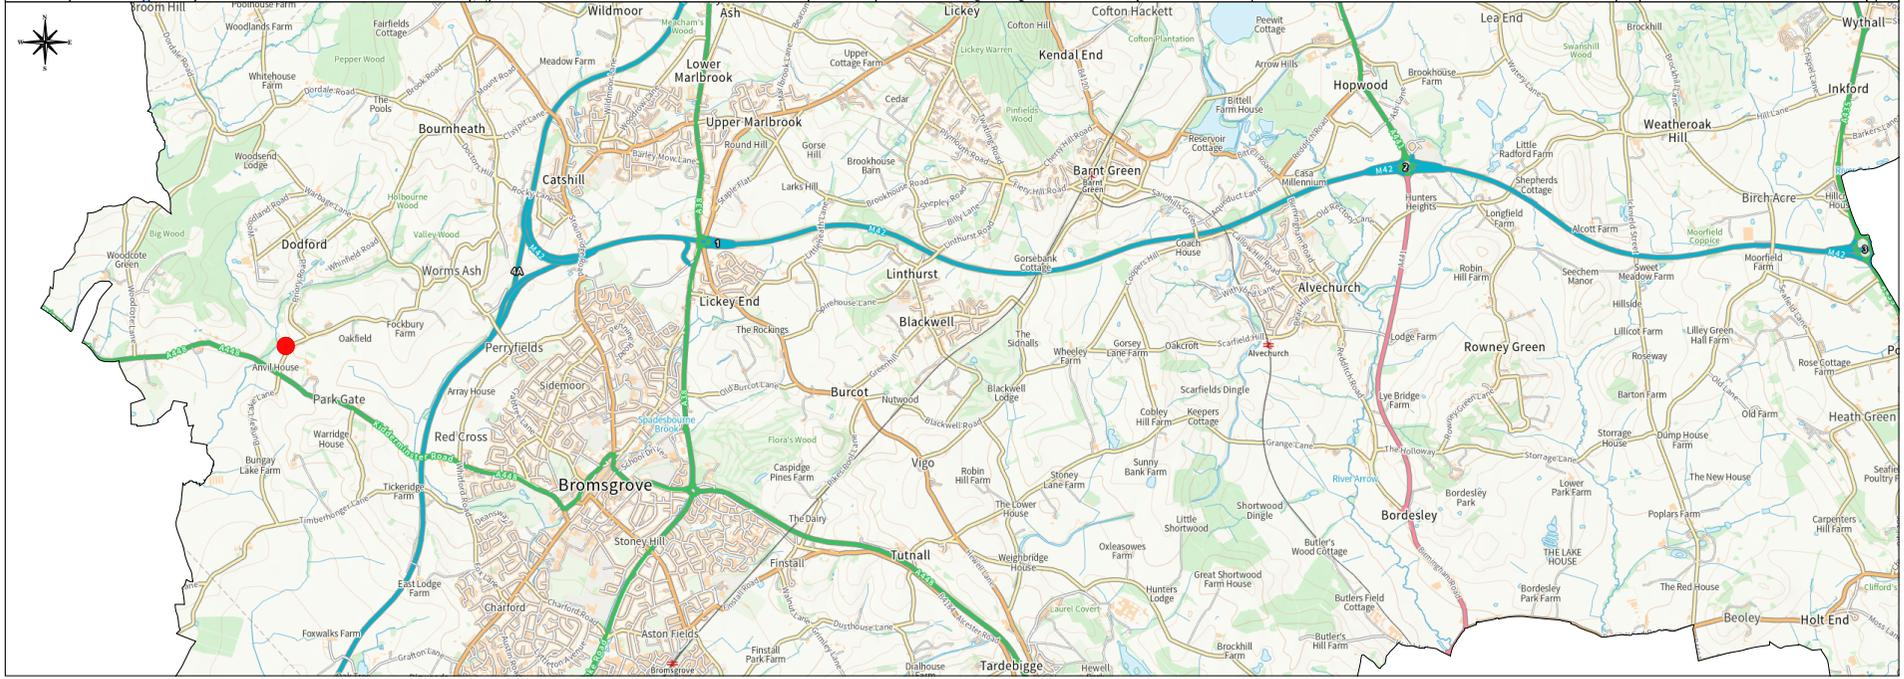


# Appendix 1

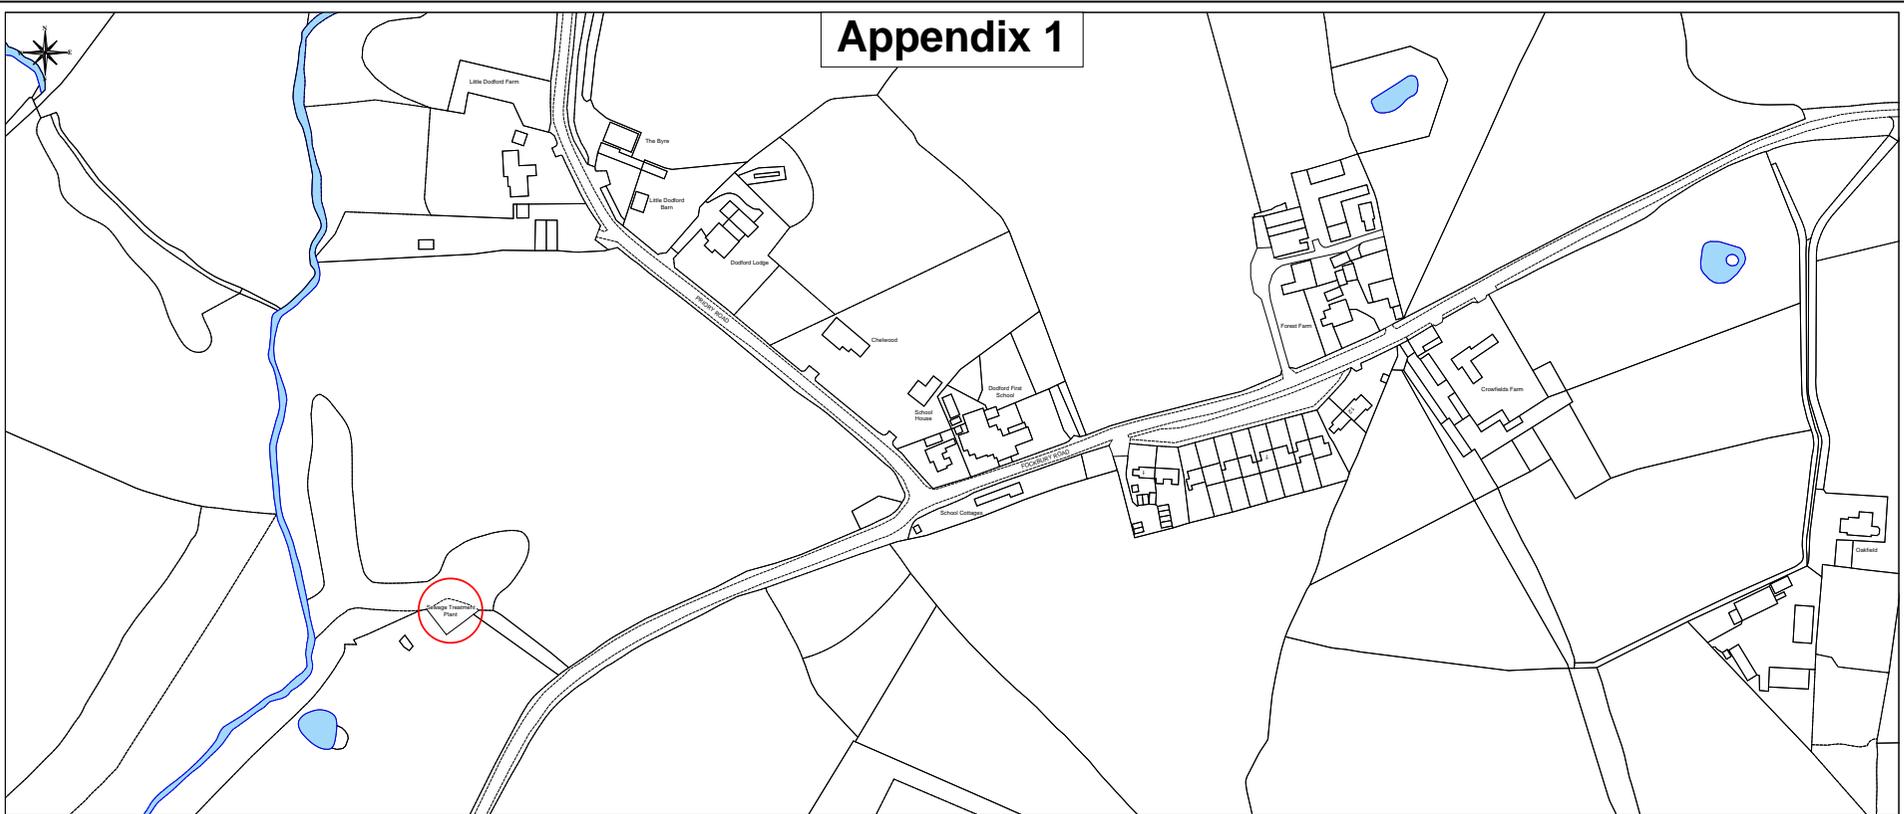

Date	Rev	Details

Project:

**Dodford Sewage Treatment Plant  
Fockbury Road  
Bromsgrove**

Drawing:

**Location and Site Plan**

Drawn:	PTL	Scale:	1/1250 and 1/25,000 @ A1
Surveyed:	OS	Date:	Mar 2022

Drawing No: **P2240/2**

Engineering and Design Services

Town Hall  
Walter Strang Square  
Redditch  
Worcestershire B98 8AH

